




REVISIONS:


DATE:  
AUGUST 28, 2012

DRAWN BY:  
AMB

SHEET TITLE:  
FLOOR PLAN -  
BELOW GRADE  
PLUMBING

SHEET NO:  
**P1.0**

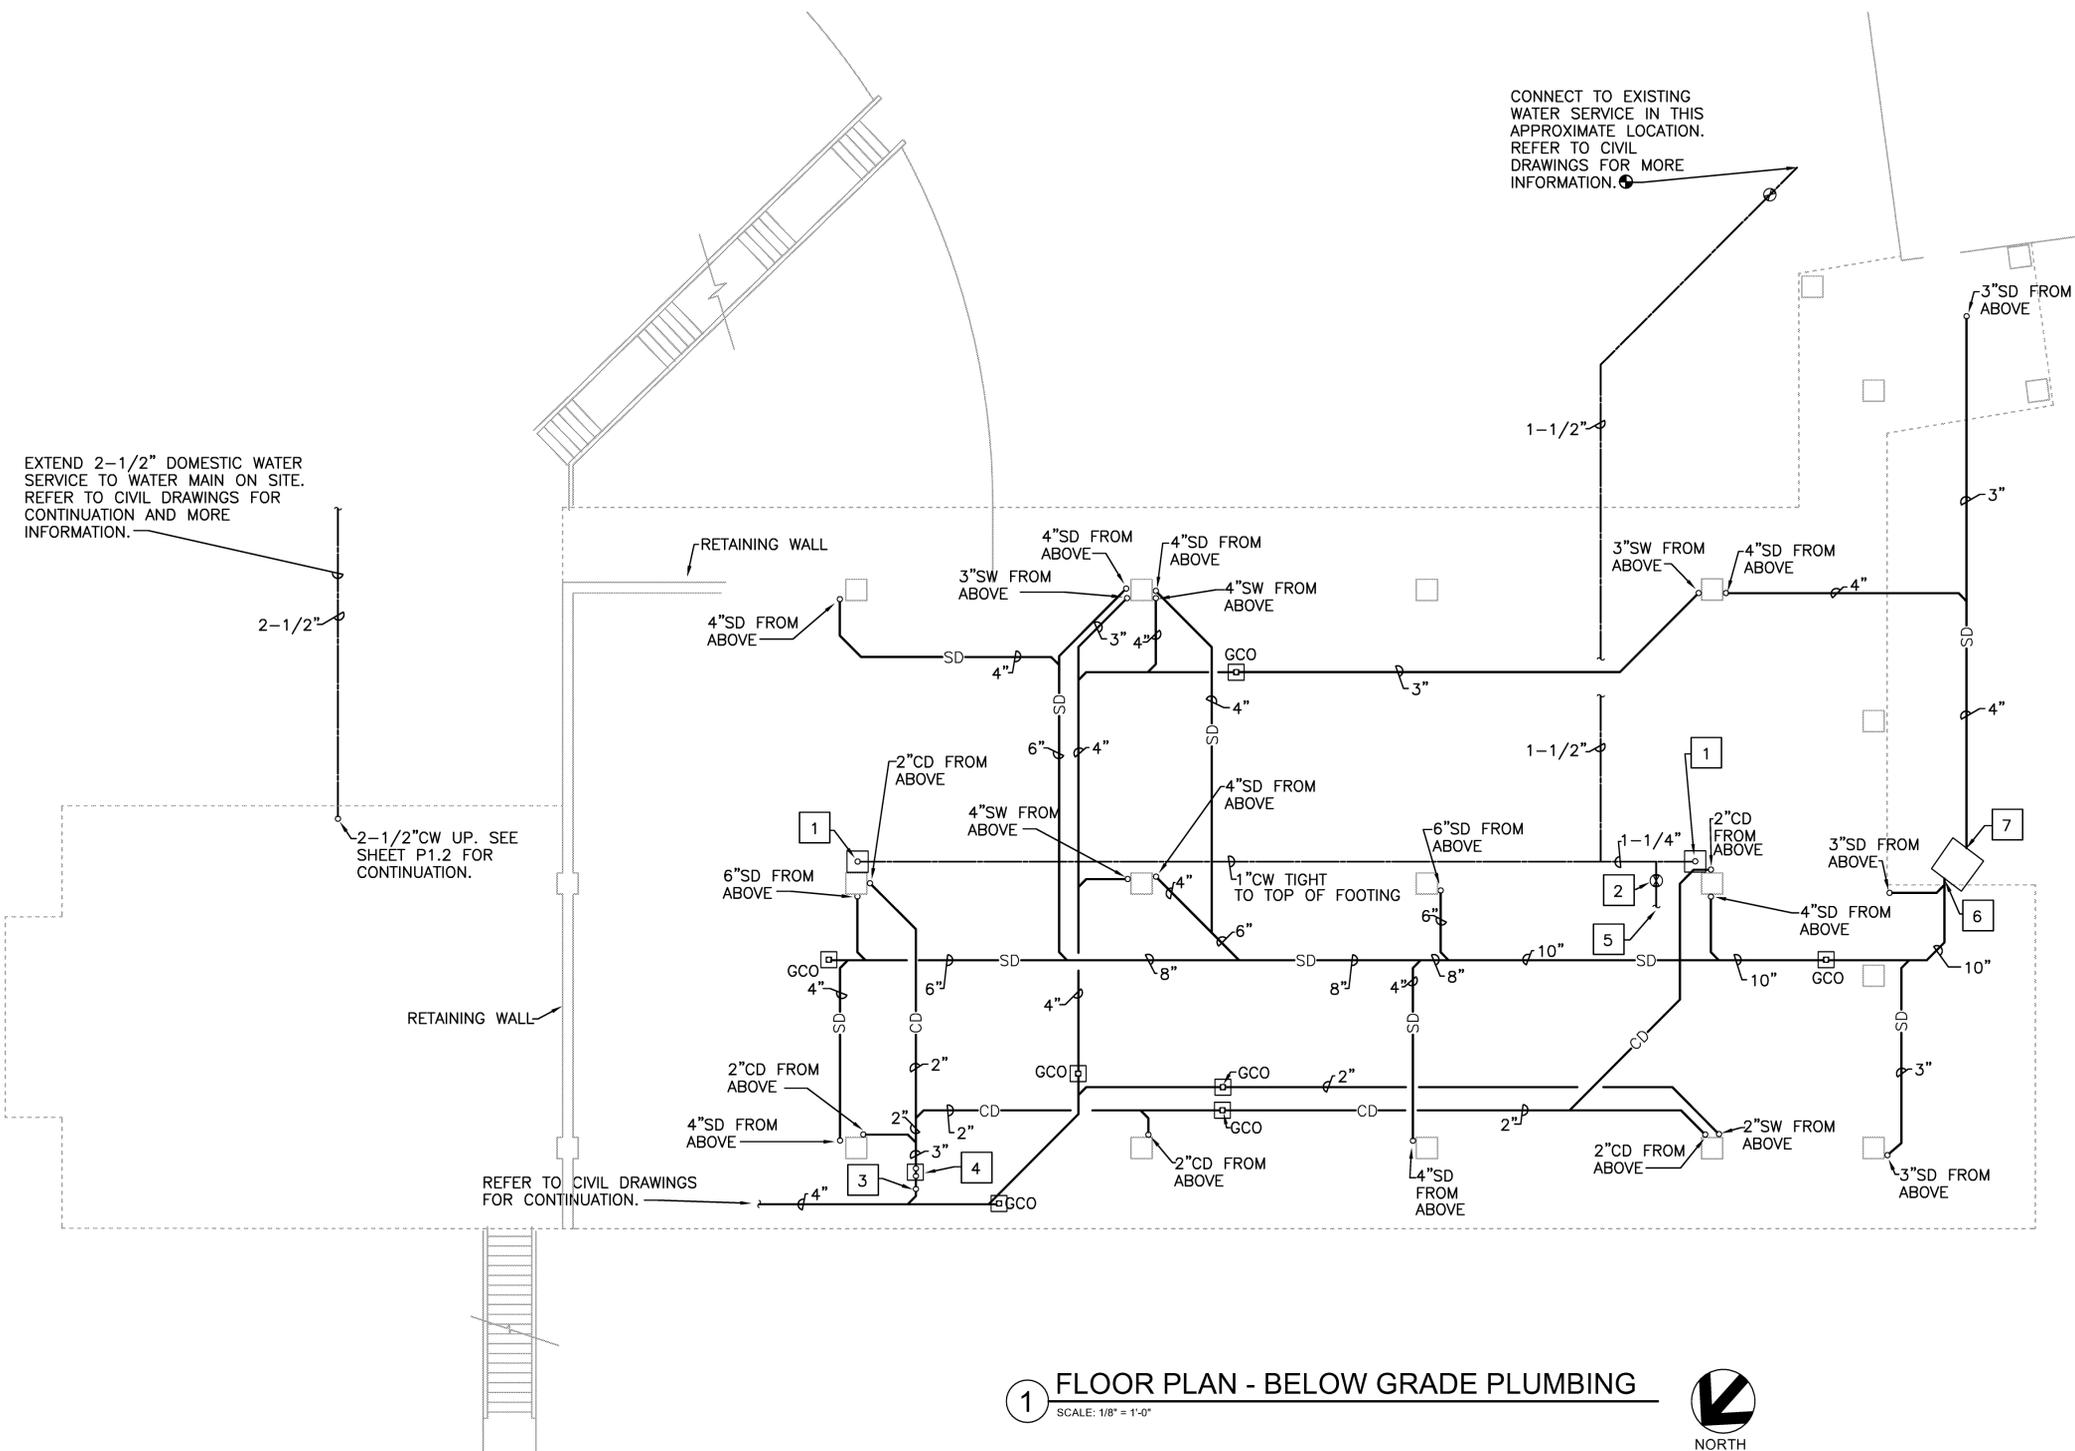

**1 FLOOR PLAN - BELOW GRADE PLUMBING**  
SCALE: 1/8" = 1'-0"  
NORTH

- KEY NOTES:
- 1 ROUTE 1" CW PIPING TO SERVE P-8 FIXTURE. COORDINATE EXACT LOCATION WITH CIVIL DRAWINGS AND OWNER PRIOR TO INSTALLATION.
  - 2 PROVIDE AND INSTALL SHUT-OFF VALVE IN BOX.
  - 3 3" CLEAN CHECK EXTENDABLE BACKWATER VALVE. SEE DETAIL SHEET FOR MORE INFORMATION.
  - 4 CITY OF MEMPHIS STYLE DEEP SEAL TRAP. EXTEND CLEANOUTS TO GRADE. SEE DETAIL SHEET FOR MORE INFORMATION.
  - 5 SEE CIVIL SERIES FOR CONTINUATION OF 1" DOMESTIC WATER FOR P-8 FIXTURE.
  - 6 CONNECT 10" STORM DRAIN TO INLET B02 @ FLOW LINE ELEVATION OF 242.00. SEE CIVIL DRAWINGS FOR EXACT INLET LOCATION AND MORE INFORMATION.
  - 7 CONNECT 4" STORM DRAIN TO INLET B02 @ FLOW LINE ELEVATION OF 242.25. SEE CIVIL DRAWINGS FOR EXACT INLET LOCATION AND MORE INFORMATION.