


REVISIONS	DATE
Δ STRUCTURAL	03.24.14

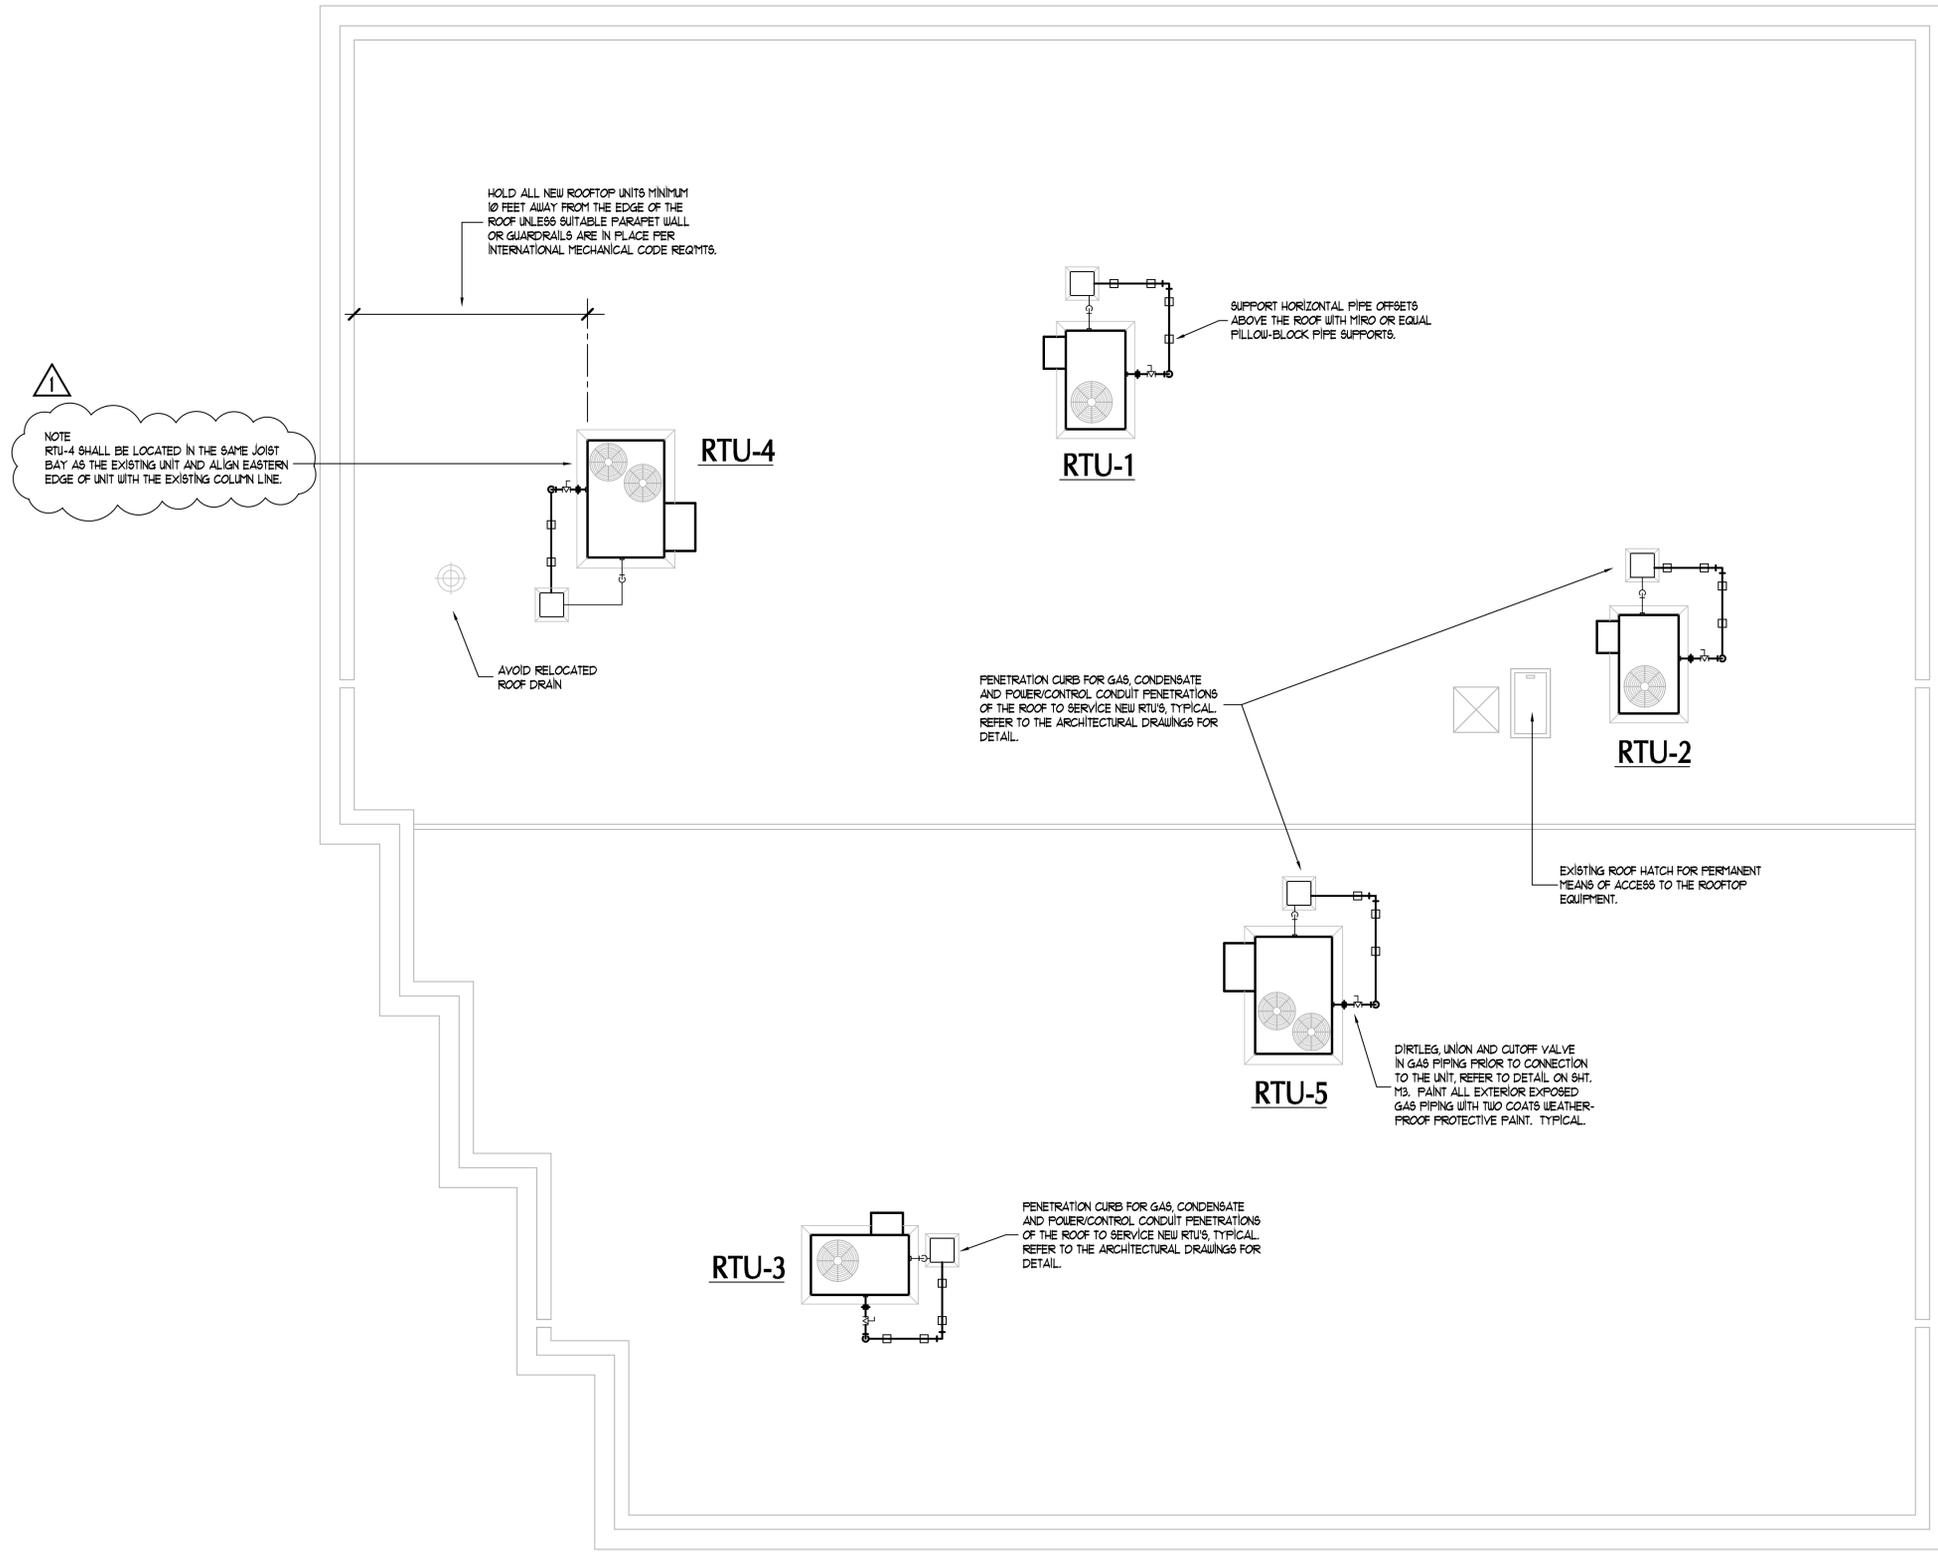

NOTE:
 REFER TO ARCHITECTURAL FOR LOCATIONS OF ALL ROOFTOP ITEMS REQUIRING CURB, PIPE OR VENT STACK EXTENSIONS UNDER SCOPE OF THIS CONTRACT AS WELL AS INFORMATION REGARDING STEEL ROOF DECK IN-FILLS, EQUIPMENT AND DECK ALTERATIONS, NEW SPRAY FOAM DECK INSULATION AND ADD ALTERNATE BID ITEM FOR NEW SUSPENDED ACOUSTIC TILE CEILING INSTALLATION.

ROOF PLAN - HVAC
 3/16" = 1'-0"

BCM
 BARHAM / CAIN / MYNATT
 incorporated
 CONSULTING ENGINEERS
 1015 Cordova Station Road Cordova, Tennessee 38018
 Phone: (901) 685-2571 Fax: (901) 682-0233
 E-mail: lerry@barhamcainmynatt.com
 E-mail: william@barhamcainmynatt.com

PROJECT TITLE: Shelby County Corrections Re-Entry Program HVAC RENOVATION 1362 Mississippi Blvd Memphis, TN 38106	
PROJECT NO. CE13044	DRAWN BY: TM/WD
DATE: 1.31.2014	DESIGNED BY: STM
SCALE: AS NOTED	CHECKED BY: DEC
SHEET TITLE: HVAC ROOF PLAN	SHEET NUMBER: M2